


ARENA CLASSROOMS B-94 & B-95 RENOVATION

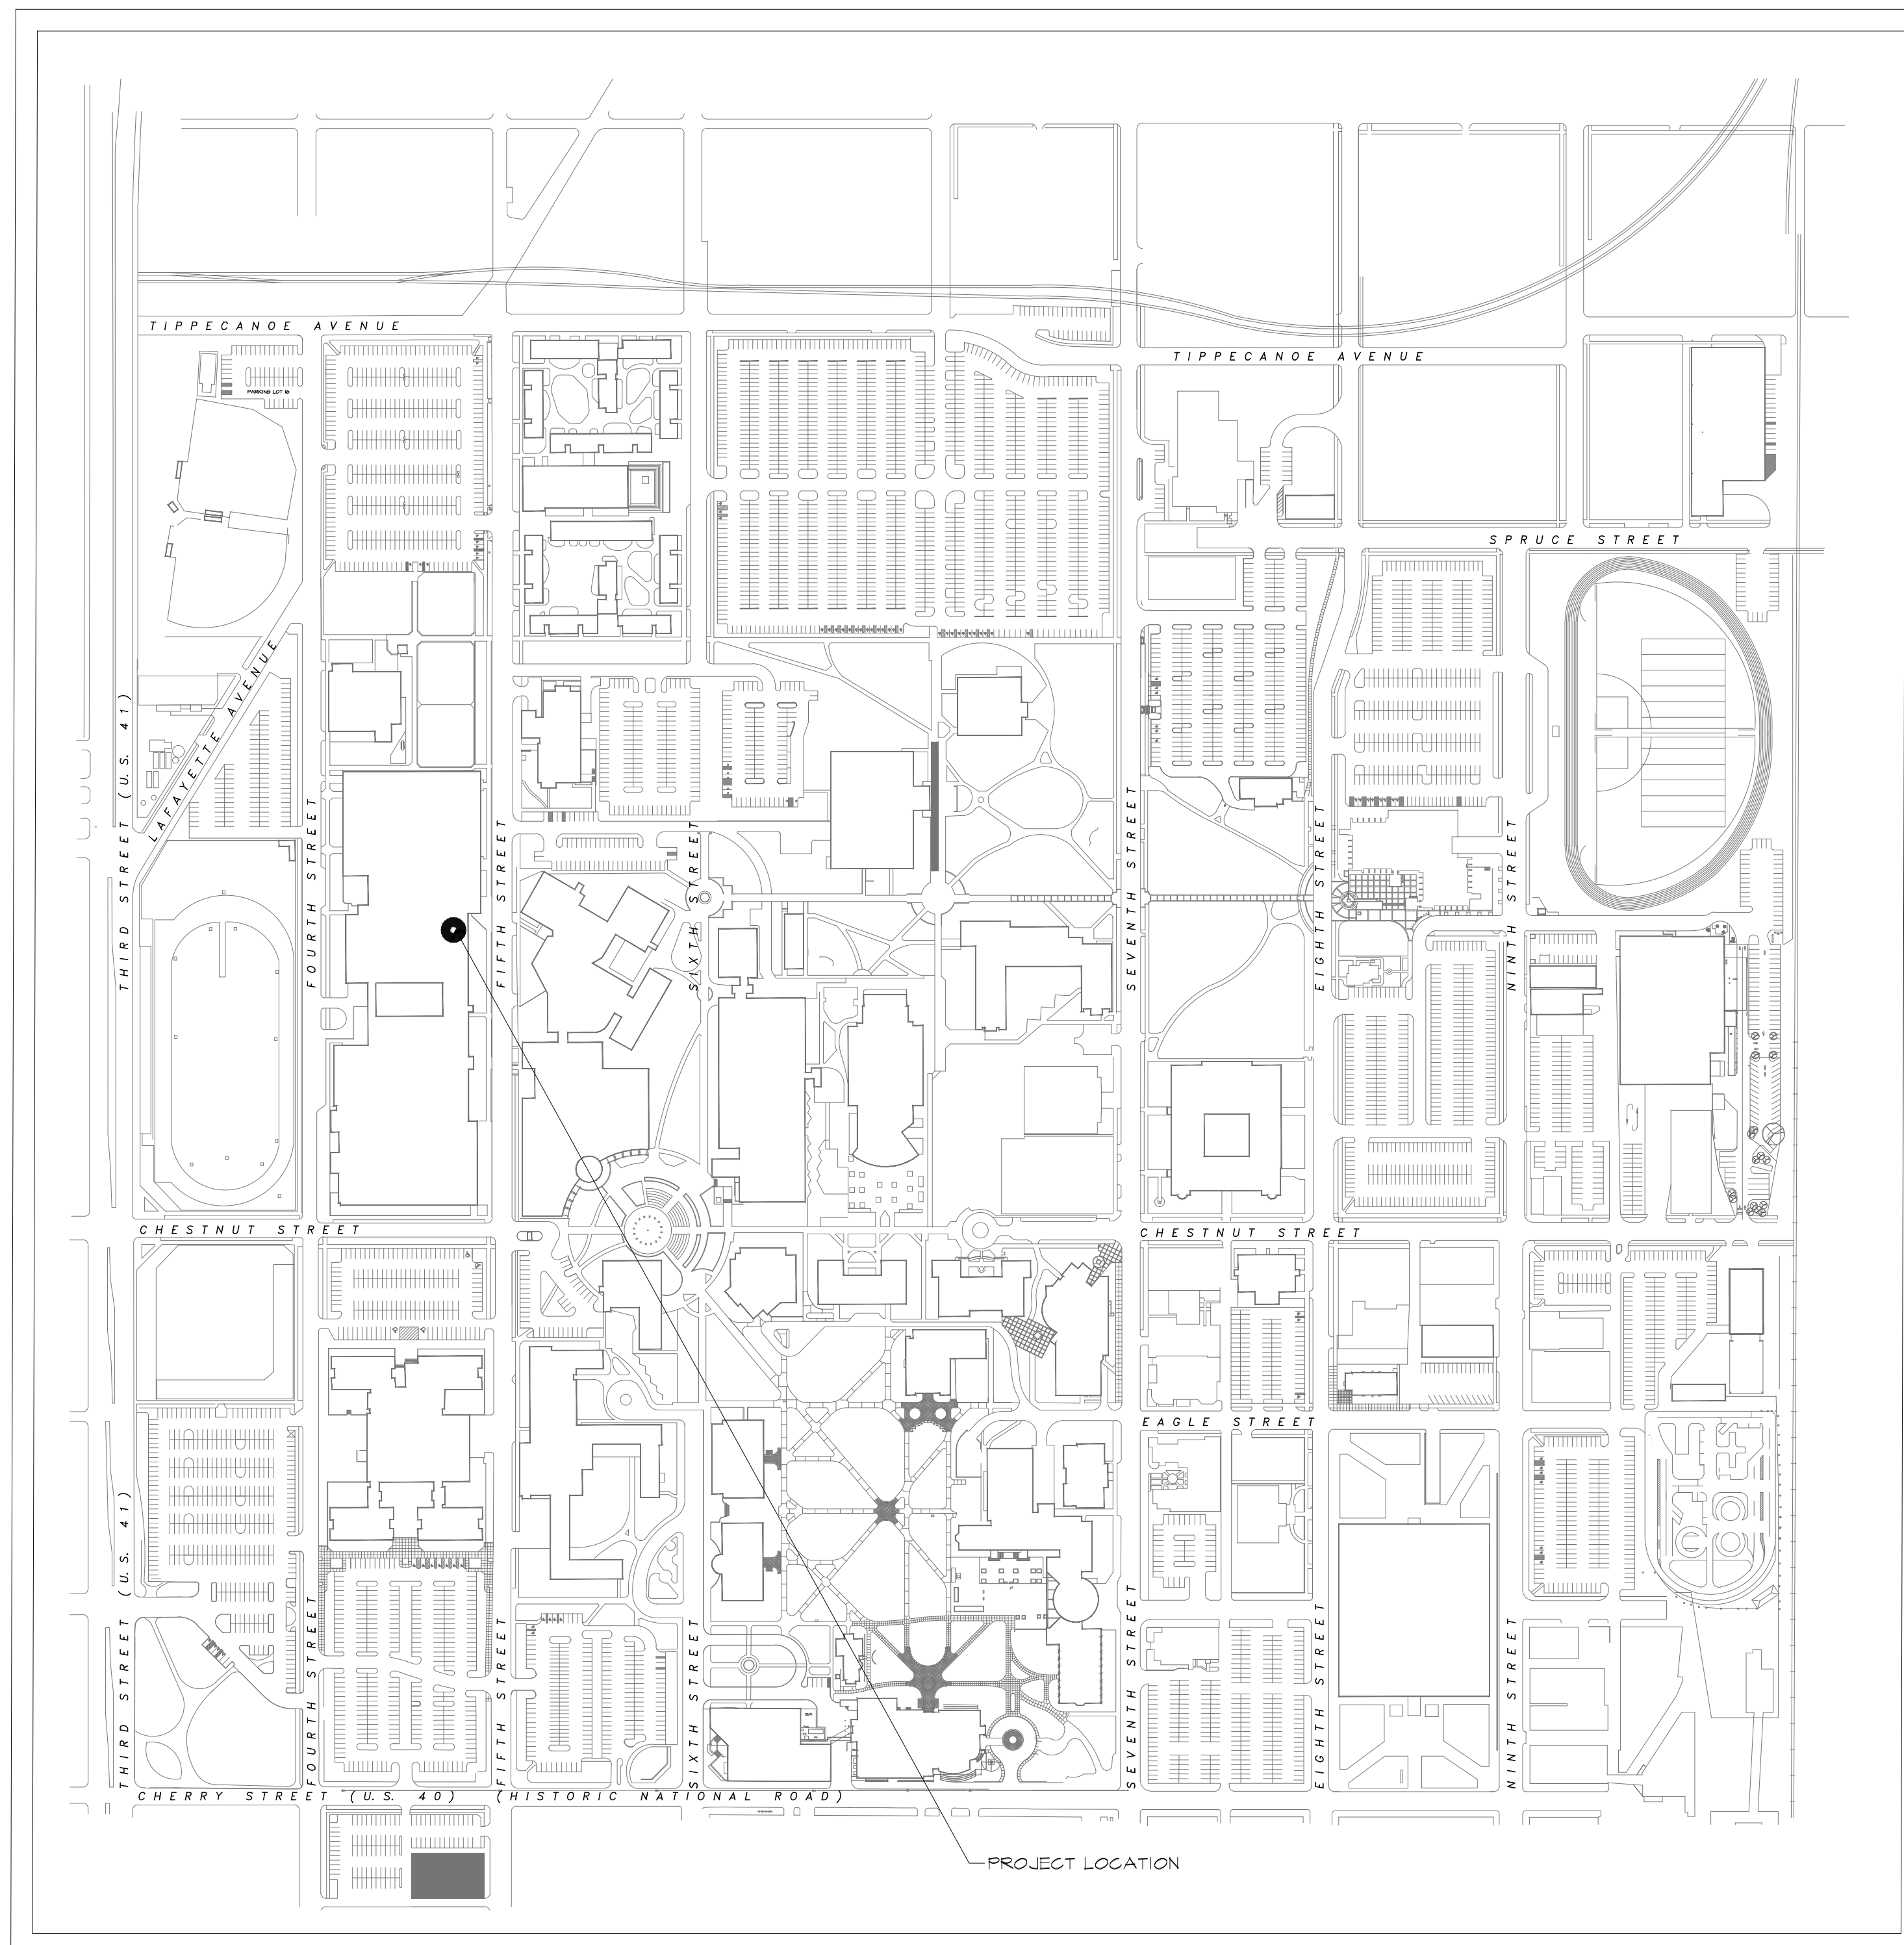

PROJECT LOCATION MAP

DRAWING INDEX

CIVIL

DEMOLITION
D101 DEMOLITION PLAN

ARCHITECTURAL
A101 FLOOR PLAN

ELECTRICAL


E101 ELECTRICAL PLAN
E102 LIGHTING PLAN

MECHANICAL

PLUMBING


FIRE PROTECTION

INDIANA STATE UNIVERSITY

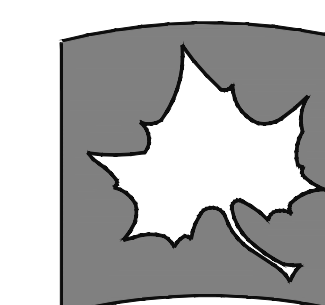


Facilities Management
951 Sycamore Street
Terre Haute, IN 47809
phone: (812) 237-8100 fax: (812) 237-7630

DATE: 9/17/2026 PROJ. NO.: B0028848

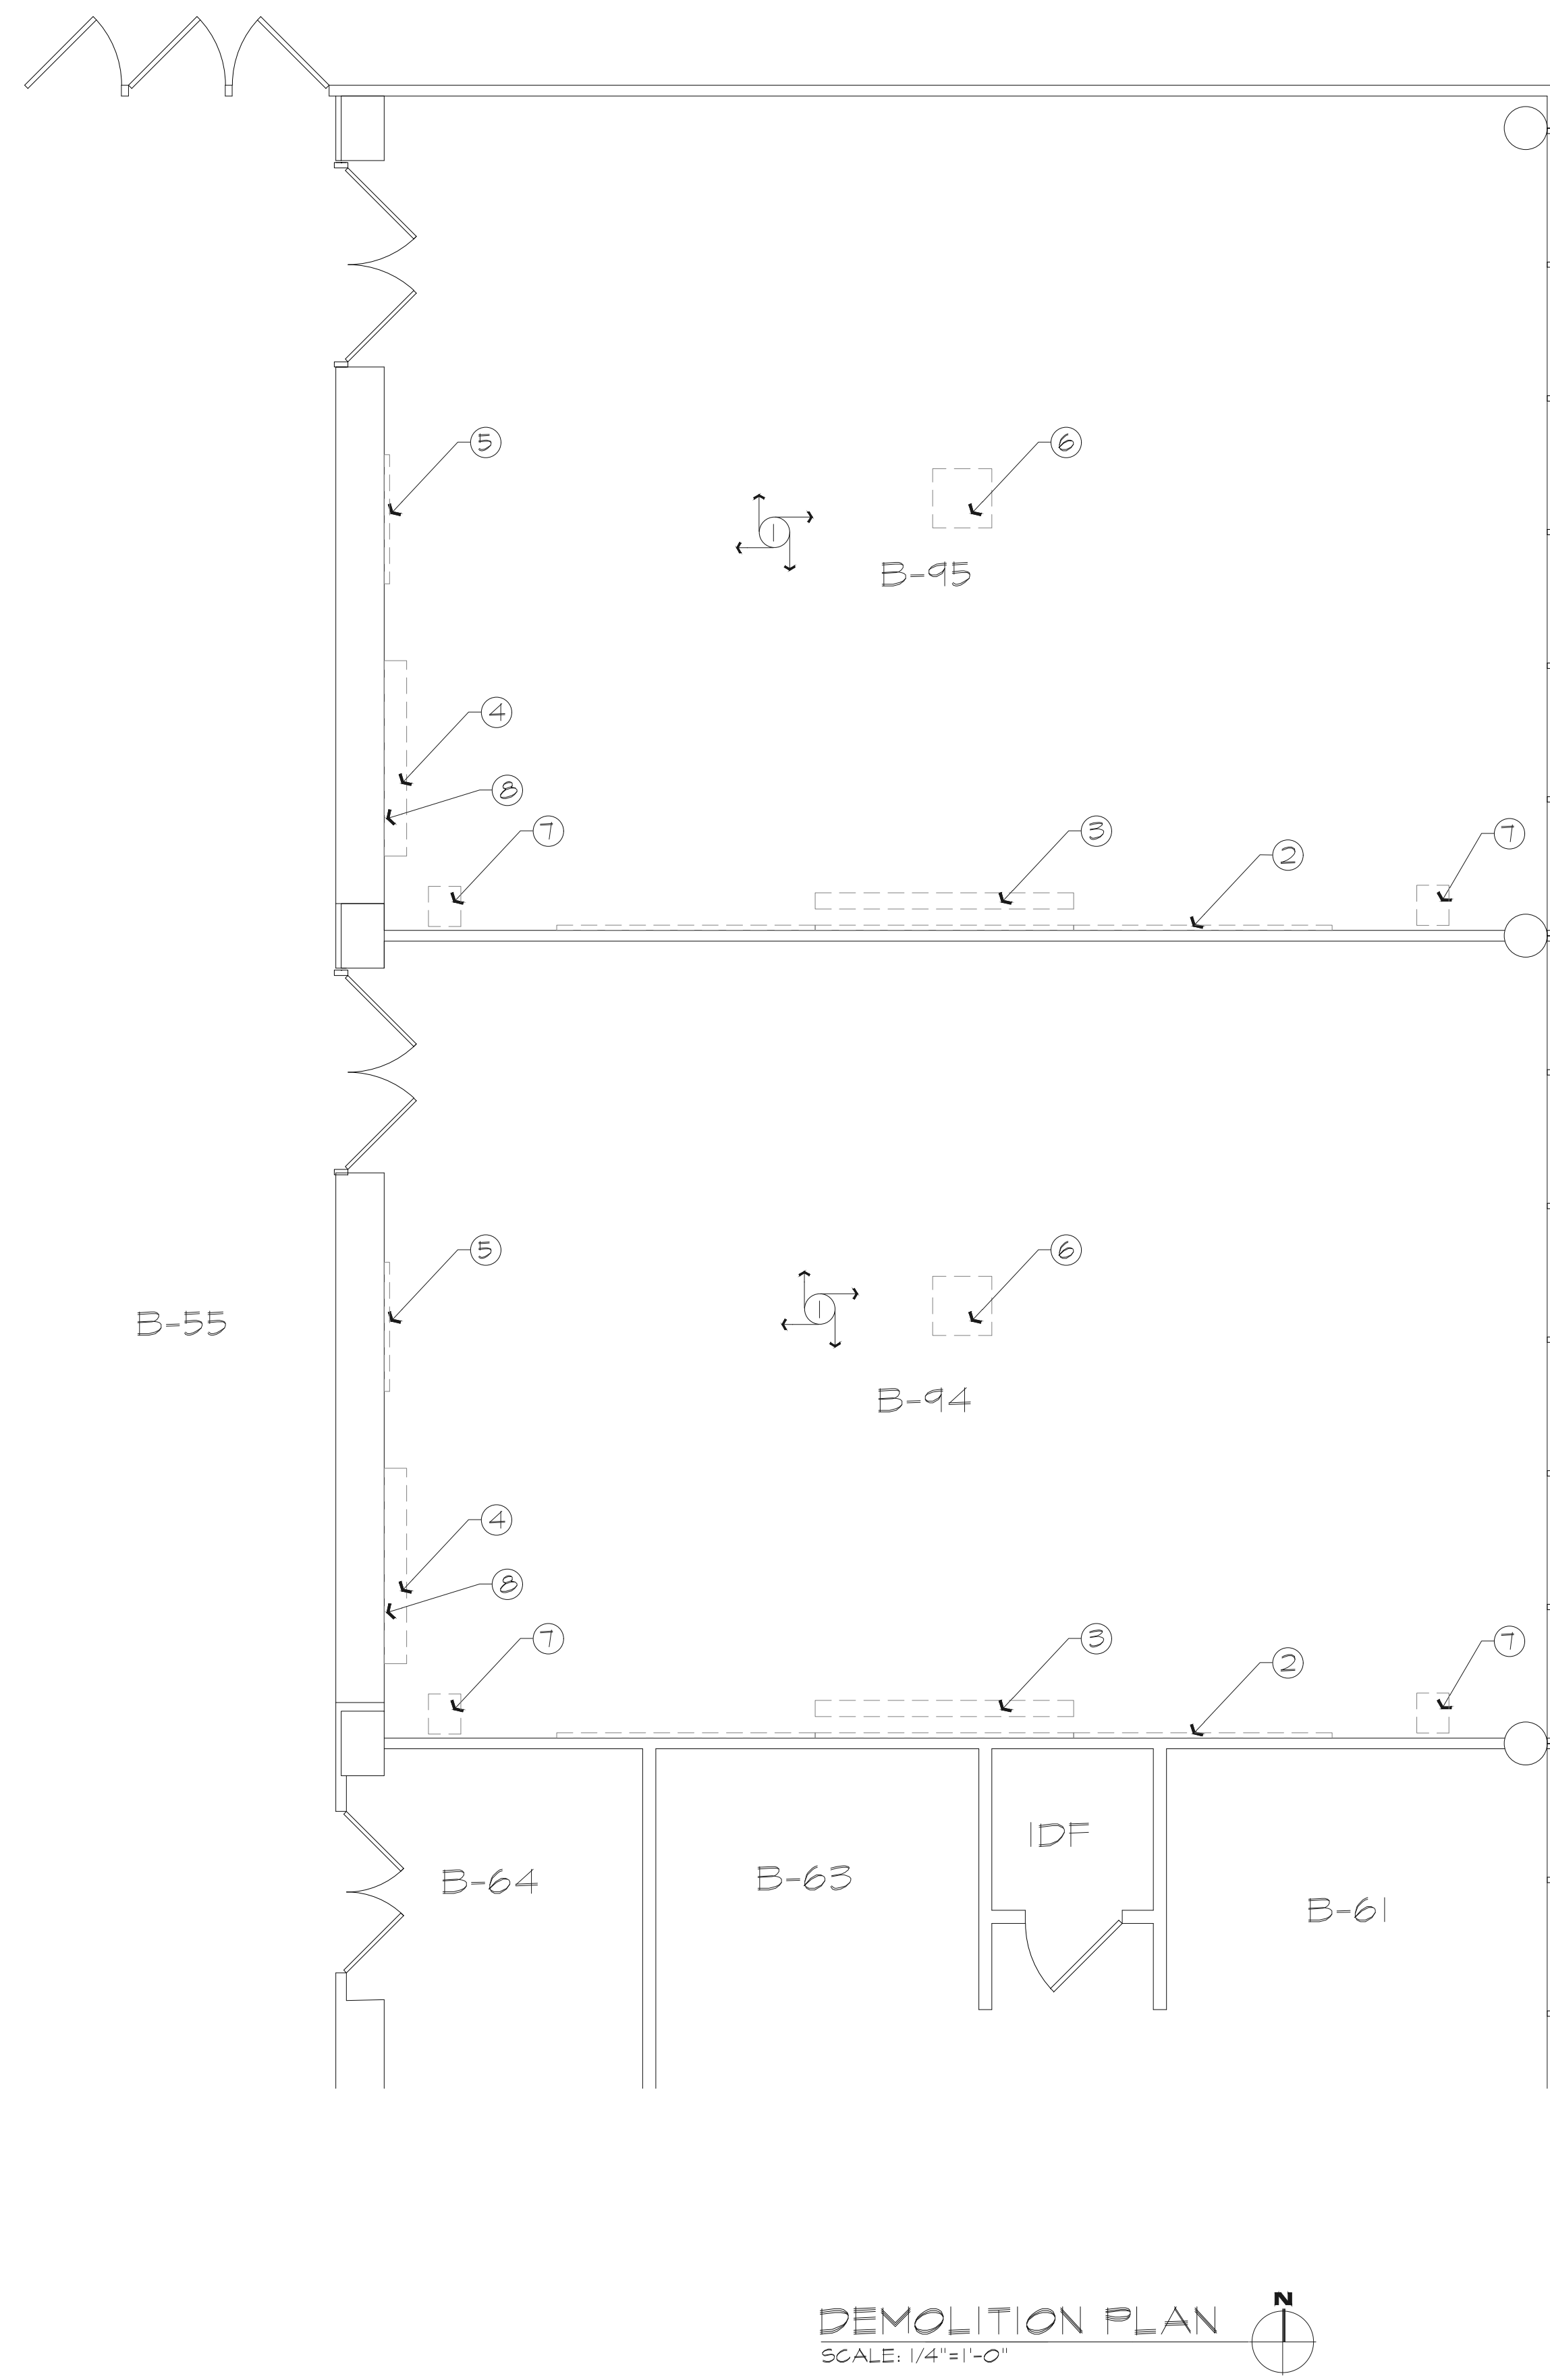

DEMOLITION NOTES:

- 1 REMOVE EXISTING CEILING AND LIGHTING COMPLETE.
REMOVE EXISTING SURFACE MOUNTED ELECTRICAL AND IN-WALL
ELECTRICAL WIRING COMPLETE AROUND THE ROOM.
REMOVE ALL DATA LINES TO ABOVE CEILING AREA.
- 2 REMOVE EXISTING CHALK BOARDS COMPLETE.
- 3 REMOVE EXISTING PROJECTION SCREEN COMPLETE.
TURN OVER TO OWNER.
- 4 REMOVE EXISTING COAT RACK / SHELF COMPLETE.
- 5 REMOVE EXISTING TACK BOARD COMPLETE.
- 6 REMOVE EXISTING PROJECTOR COMPLETE.
TURN OVER TO OWNER.
- 7 REMOVE EXISTING SPEAKERS COMPLETE.
TURN OVER TO OWNER.
- 8 REMOVE EXISTING RETURN AIR GRILL AND SAVE
FOR RE-USE. PAINT GRILL TWO COATS WHITE.

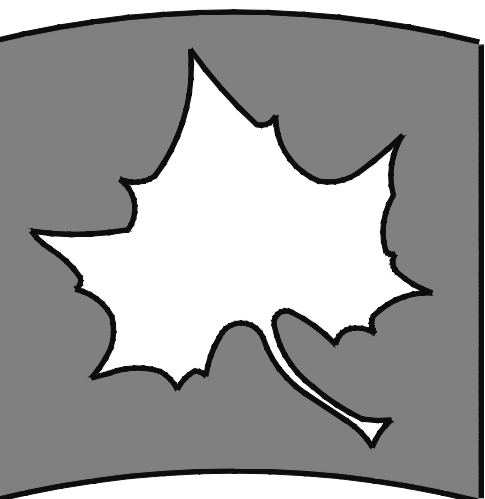

INDIANA STATE UNIVERSITY

Facilities Management Department
951 Sycamore Street
Terre Haute, Indiana 47809
Phone: (812) 237-2100 Fax: (812) 237-7630

ARENA BUILDING CLASSROOMS
B-94 AND B-95 RENOVATIONS


DEMOLITION PLAN

FILENAME:	
PROPERTY NO:	
REVISIONS	
1	
2	
DATE:	9/21/2026
SCALE:	1/4"=1'-0"
DRAWN BY:	S.TILLMAN
CHECKED BY:	B.DUNCAN
APPROVED BY:	
PROJECT NO:	

SHEET NO.:

D101


OF SHEETS

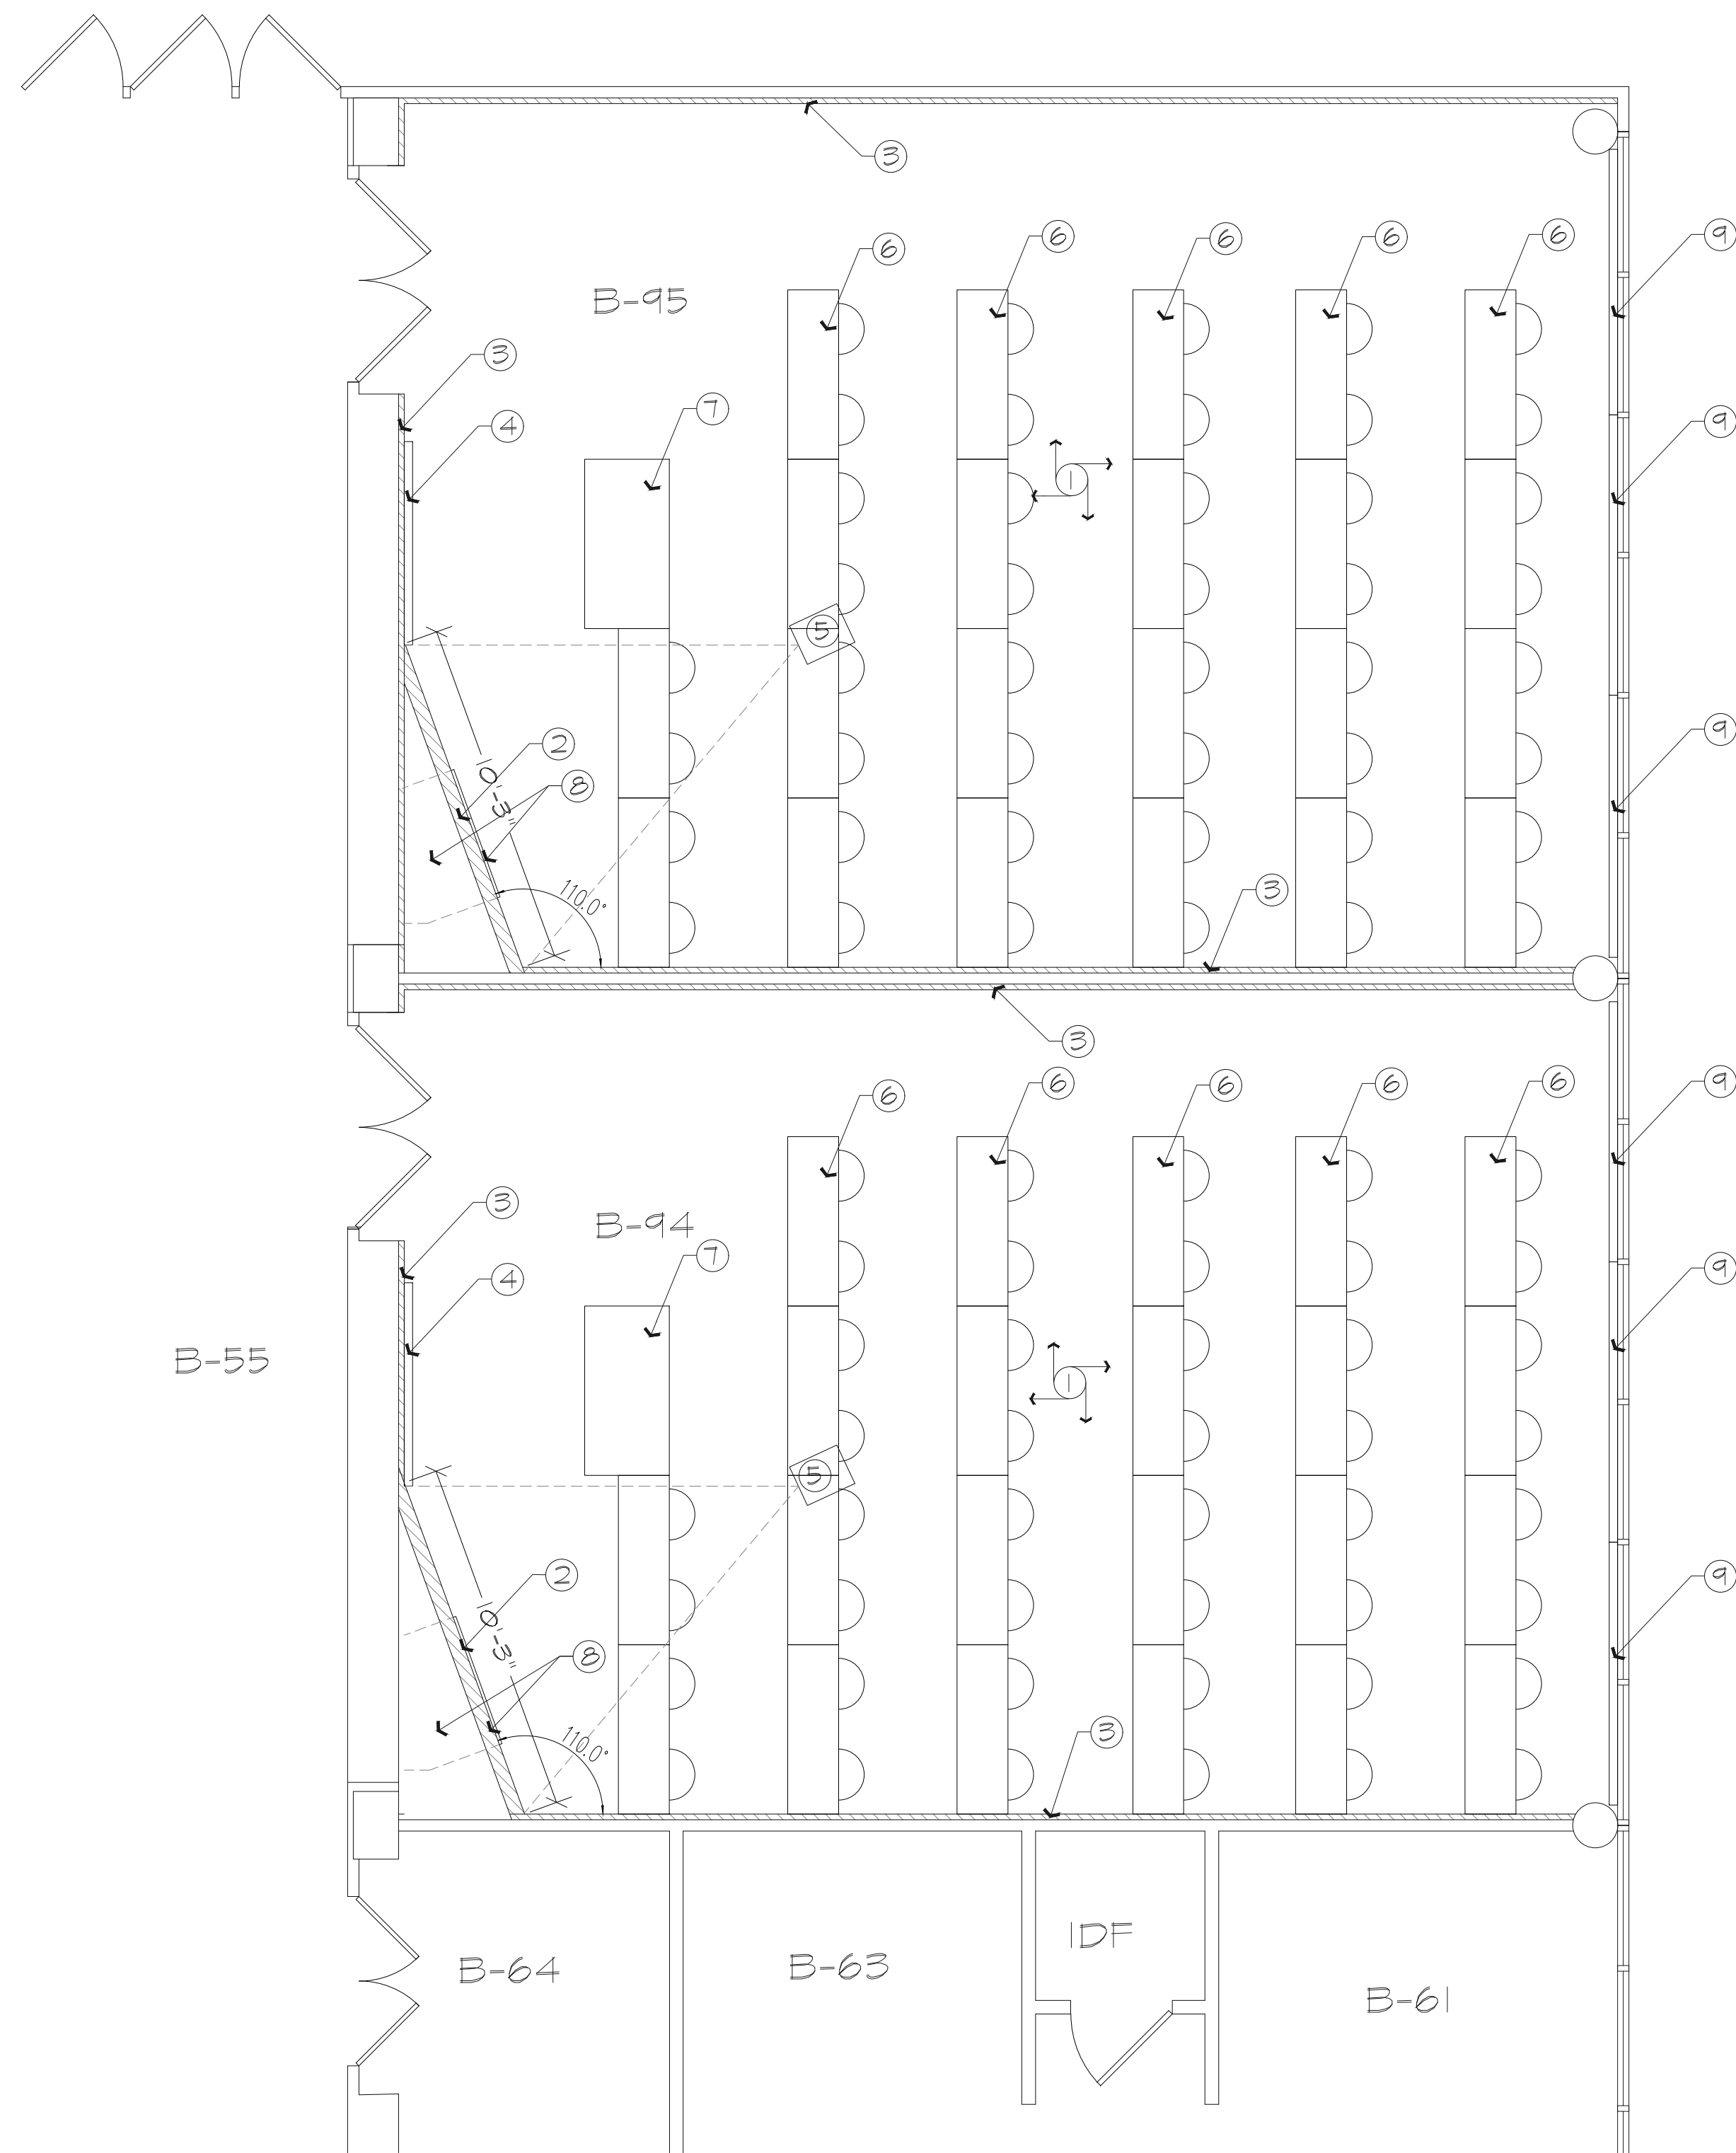

FLOOR PLAN
SCALE: 1/4"=1'-0"

PLAN NOTES:

1. INSTALL CARPETING OVER EXISTING VINYL TILE FLOORING. CARPETING SHALL BE "MILLIKEN" "LOUDSPEAKER" "TWEETER" IN COLOR # TWE52 BLUE CHROMA. PRIME AND PAINT WALLS TWO FINISH COATS IN COLOR SELECTED BY OWNER. INSTALL 4" VINYL BASE IN COLOR SELECTED BY OWNER.
2. CONSTRUCT A 3 5/8" METAL STUD WALL TO 10'-0" A.F.F. WITH 5/8" DRYWALL ON ROOM SIDE ONLY. THIS WALL SHALL BE USED AS A PROJECTION SURFACE AND SHALL BE PAINTED IN A MATT WHITE COLOR AS SELECTED BY OWNER. INSTALL 4" VINYL BASE IN COLOR SELECTED BY OWNER.
3. INSTALL 1 5/8" METAL STUD AND 5/8" DRYWALL WALL OVER EXISTING BLOCK WALLS. PRIME AND PAINT WALL TWO FINISH COATS IN COLOR SELECTED BY OWNER. INSTALL 4" VINYL BASE IN COLOR SELECTED BY OWNER.
4. INSTALL A MAGNETIC GLASS MARKER BOARD AS "CLARUS" "CLARO-ULTRA" IN SIZE 4' X 6', MODEL# CU-MG-WH-48x72-FC.
5. CEILING MOUNTED PROJECTOR BY ISU.
6. CLASSROOM TABLES AND CHAIRS BY ISU.
7. INSTRUCTOR SYMPOSIUM BY ISU.
8. PAINT AND RE-INSTALL THE METAL RETURN AIR GRILL IN NEW WALL. BOTTOM OF GRILL @ 6" A.F.F. INSTALL NEW DUCTWORK FROM EXISTING WALL TO NEW LOCATION.
9. INSTALL MANUAL CONTROL ROOM DARKENING "ZEBRA" ROLLER SHADES. THIS WILL BE INCLUDED AS PART OF ALLOWANCE #1 COSTS.

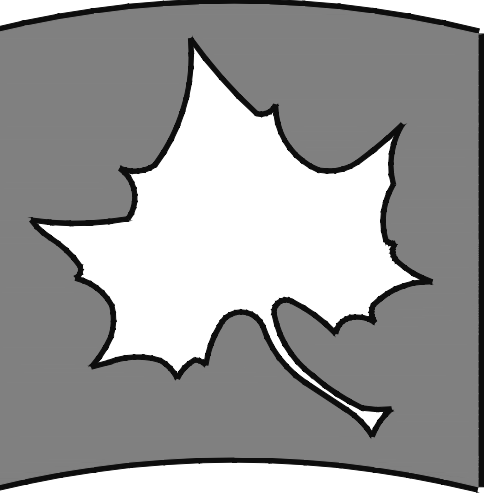

INDIANA STATE UNIVERSITY
Facilities Management Department
951 Sycamore Street
Terre Haute, Indiana 47809
Phone: (812) 237-8100 Fax: (812) 237-7630


ARENA BUILDING CLASSROOMS
B-94 AND B-95 RENOVATIONS
FLOOR PLAN

FILENAME:	
PROPERTY NO.:	
REVISIONS	
1	
2	
DATE:	9/21/2026
SCALE:	1/4"=1'-0"
DRAWN BY:	S.TILLMAN
CHECKED BY:	B.DUNCAN
APPROVED BY:	
PROJECT NO.:	

SHEET NO.:

A101


OF SHEETS

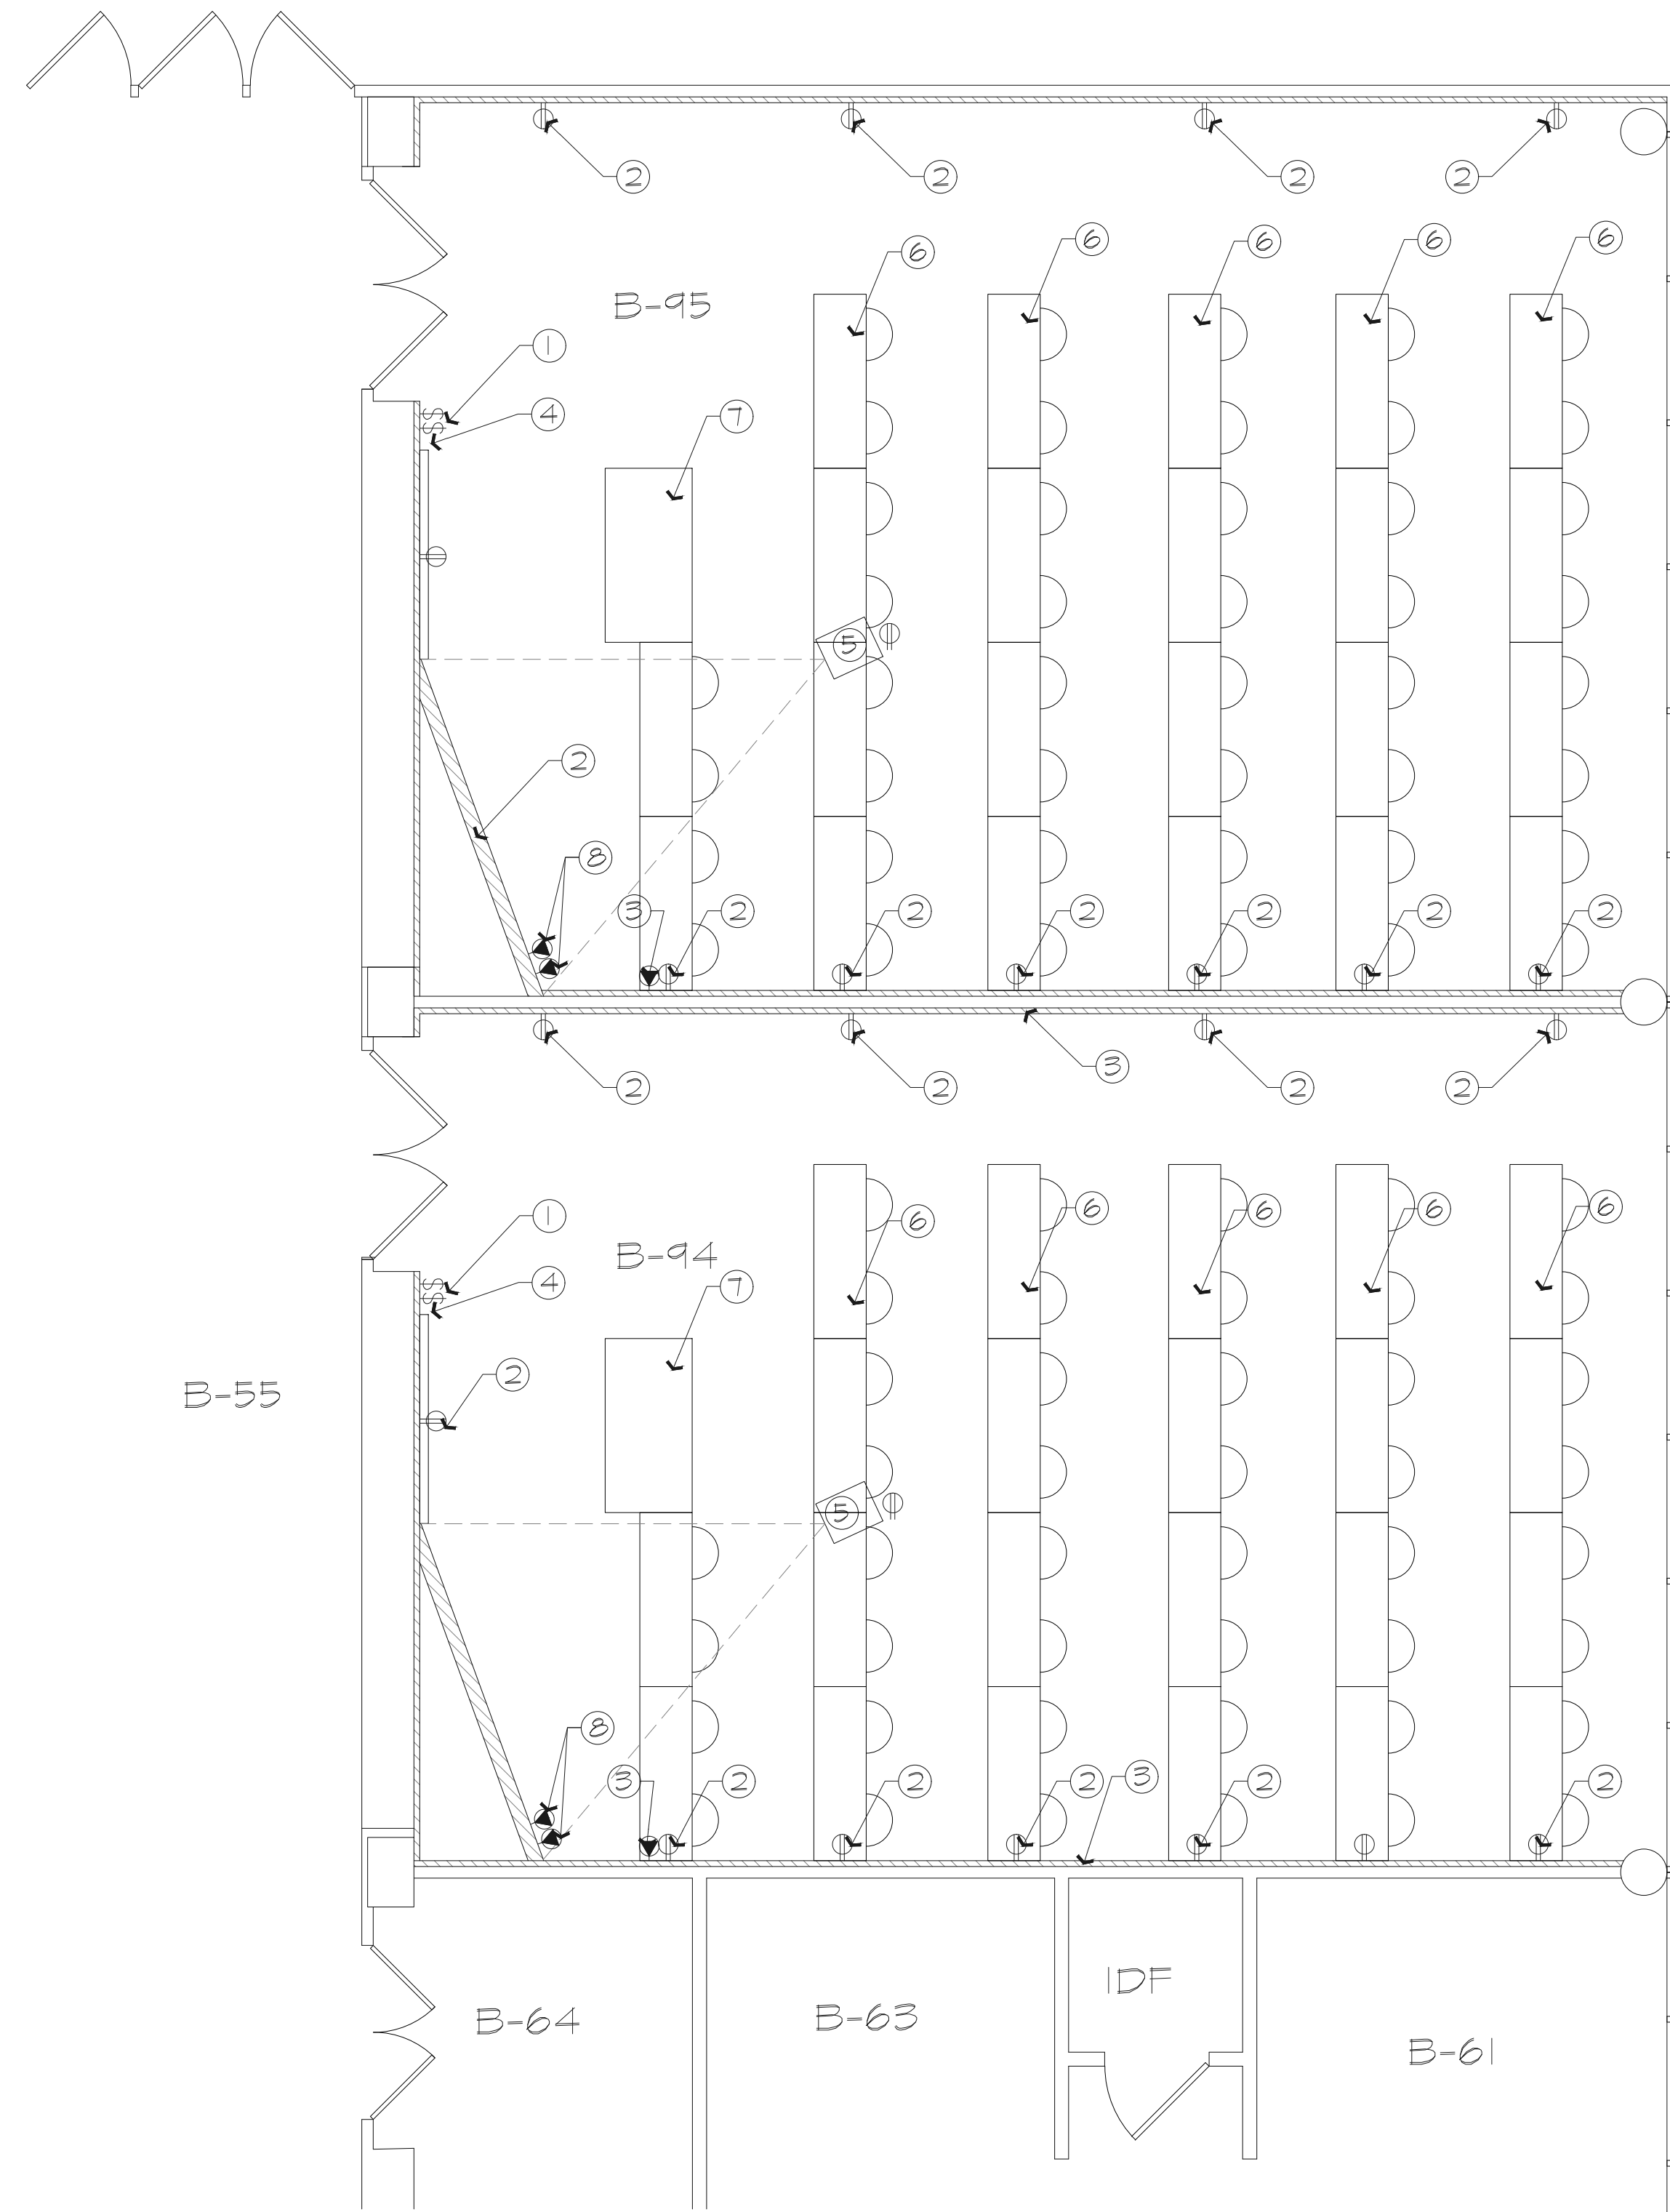

ELECTRICAL PLAN
SCALE: 1/4"=1'-0"

ELECTRICAL NOTES:

- ① INSTALL NEW LIGHT SWITCHES AS: "CURRENT" #RSD0108 WITH LIGHTING CONTROL #UVPPHD AND OCCUPANCY SENSOR AS: "OMNI" # DT2000
- ② INSTALL NEW DUPLEX OUTLETS @ 15" A.F.F.
- ③ RE-INSTALL EXISTING SYMPOSIUM JUNCTION BOX AND EQUIPMENT. ALL CABLES WILL BE RAN UNDERNEATH NEW TABLES IN WIRE MANAGEMENT TRAY. ISU WILL COORDINATE THE WIRING TO THE SYMPOSIUM DESK UNIT.
- ④ INSTALL A NEW THERMOSTAT.
- ⑤ INSTALL REQUIRED POWER AND ALL DATA LINES TO CEILING MOUNTED PROJECTOR. PROVIDE REQUIRED CEILING GRID SUPPORT FOR THE PROJECTOR.
- ⑥ TABLES AND CHAIRS BY ISU. THESE ARE NOT IN CONTRACT AND ARE REFERENCE ONLY.
- ⑦ INSTRUCTOR SYMPOSIUM BY ISU. THIS IS NOT IN CONTRACT AND IS REFERENCE ONLY.
- ⑧ INSTALL A SINGLE GANG ELECTRICAL BOX 15" A.F.F. WITH A 2" CONDUIT STUBBED TO ABOVE THE CEILING.

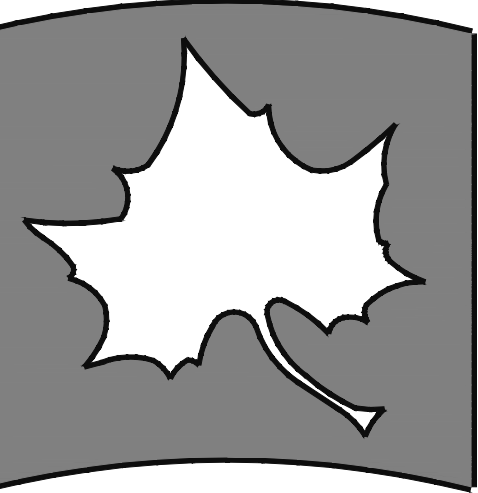

INDIANA STATE UNIVERSITY

Facilities Management Department
951 Sycamore Street
Terre Haute, Indiana 47809
Phone: (812) 237-2100 Fax: (812) 237-7630

ARENA BUILDING CLASSROOMS
B-94 AND B-95 RENOVATIONS


ELECTRICAL PLAN

FILENAME:	
PROPERTY NO:	
REVISIONS	
1	
2	
DATE:	9/21/2026
SCALE:	1/4"=1'-0"
DRAWN BY:	S.TILLMAN
CHECKED BY:	B.DUNCAN
APPROVED BY:	
PROJECT NO:	

SHEET NO.:

E101


OF SHEETS

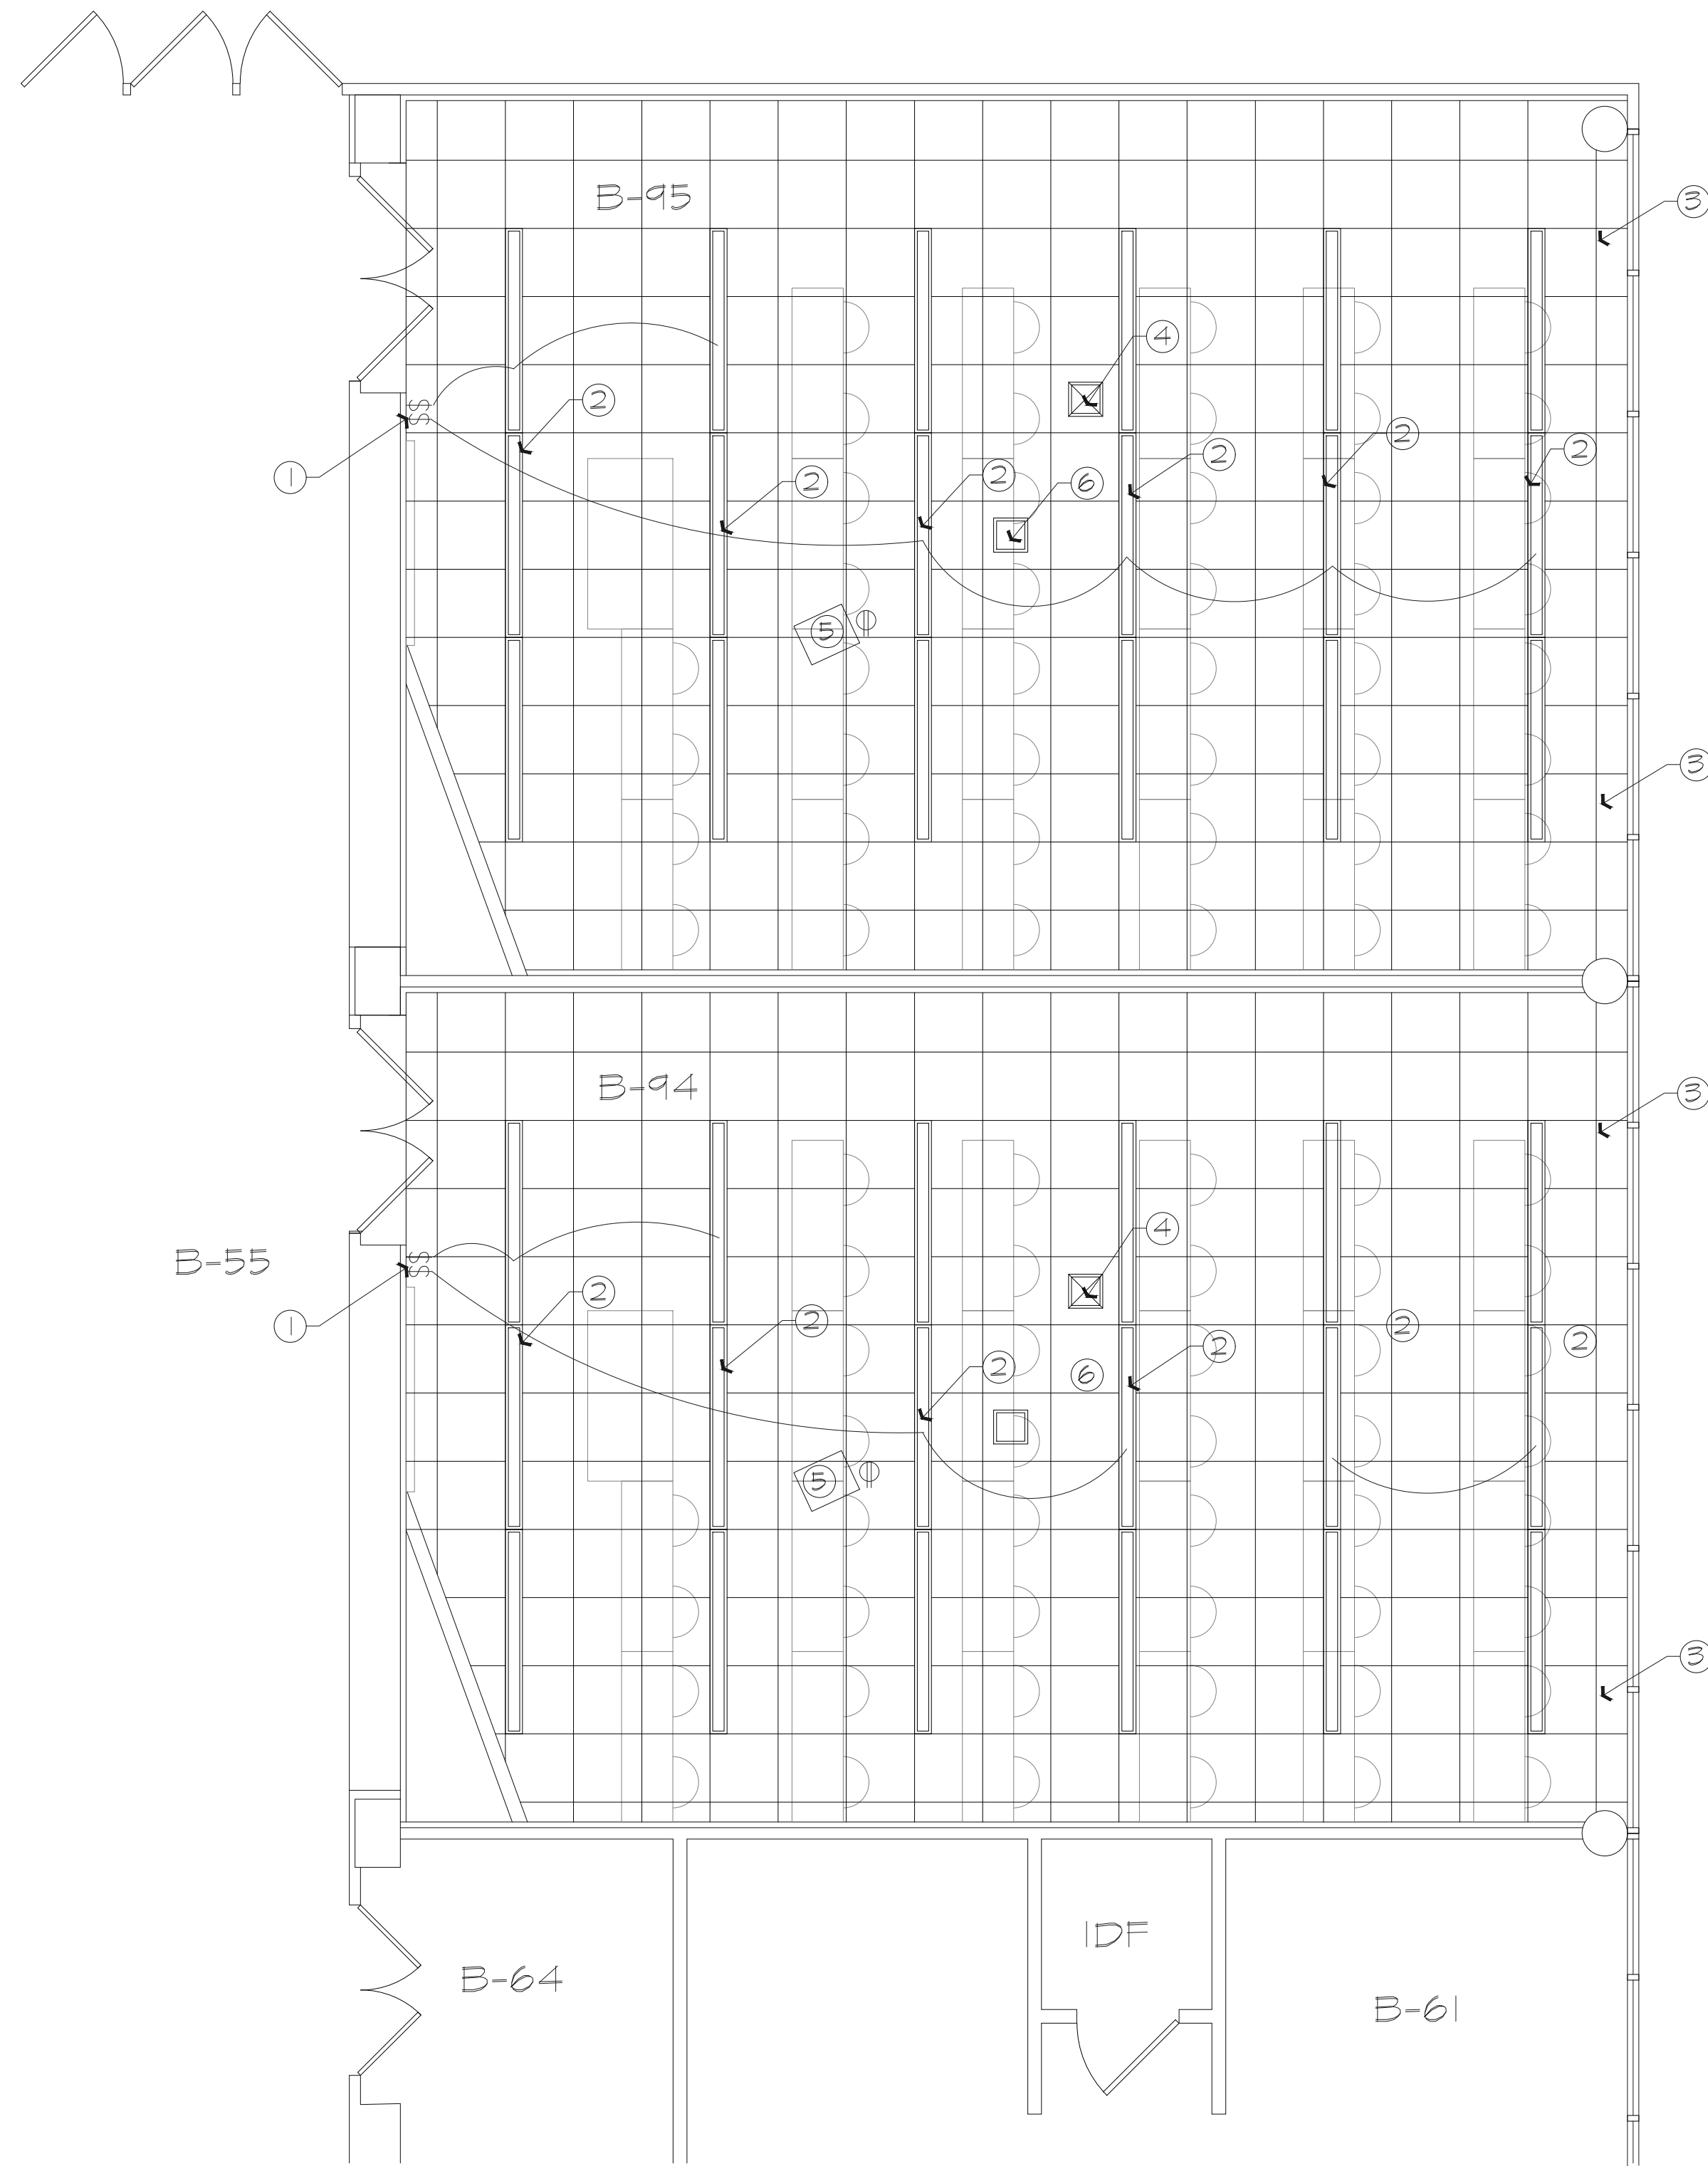

LIGHTING PLAN
SCALE: 1/4"=1'-0"

PLAN NOTES:

- ① INSTALL NEW LIGHT SWITCHES AS: "CURRENT" #RSD0108 WITH LIGHTING CONTROL #UVPPHD.
- ② INSTALL NEW LED 4" X 6' LAY-IN LIGHT FIXTURE AS: "FINELITE" HP-4-R-6'-H-8-35-F-227V-SC-C2-FLEX VERIFY EXISTING LIGHTING VOLTAGE.
- ③ INSTALL 2' X 2' LAY-IN CEILING GRID AS: "USG" DONN 9/16" IN WHITE
INSTALL 2' X 2' LAY-IN CEILING TILE AS: "USG" ORION 85 WITH FINELINE BEVEL EDGE.
- ④ RE-INSTALL EXISTING CEILING MOUNTED WI-FI.
- ⑤ INSTALL REQUIRED POWER AND ALL DATA LINES TO CEILING MOUNTED PROJECTOR.
- ⑥ INSTALL AN OCCUPANCY SENSOR AS: "OMNI" #DT2000

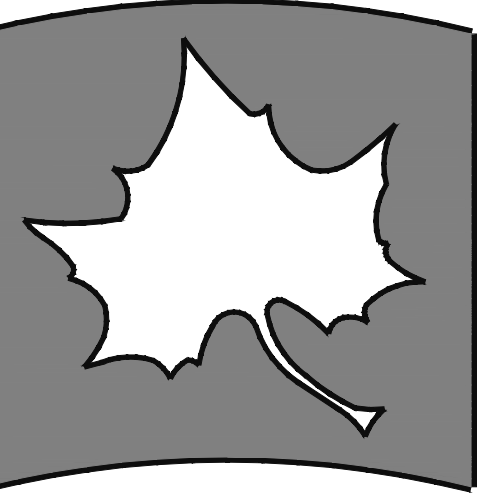

INDIANA STATE UNIVERSITY

Facilities Management Department
951 Sycamore Street
Terre Haute, Indiana 47809
Phone: (812) 237-2100 Fax: (812) 237-7630

ARENA BUILDING CLASSROOMS
B-94 AND B-95 RENOVATIONS

LIGHTING PLAN

FILENAME:	
PROPERTY NO:	
REVISIONS	
1	
2	
DATE:	9/21/2026
SCALE:	1/4"=1'-0"
DRAWN BY:	S.TILLMAN
CHECKED BY:	B.DUNCAN
APPROVED BY:	
PROJECT NO:	

SHEET NO.:

E102

OF SHEETS